





PROJECT SITE:

DISCOUNT TIRE VAC 12457
1636 SEMINOLE TRAIL
CHARLOTTESVILLE, VA 22901


SIGN PACKAGE

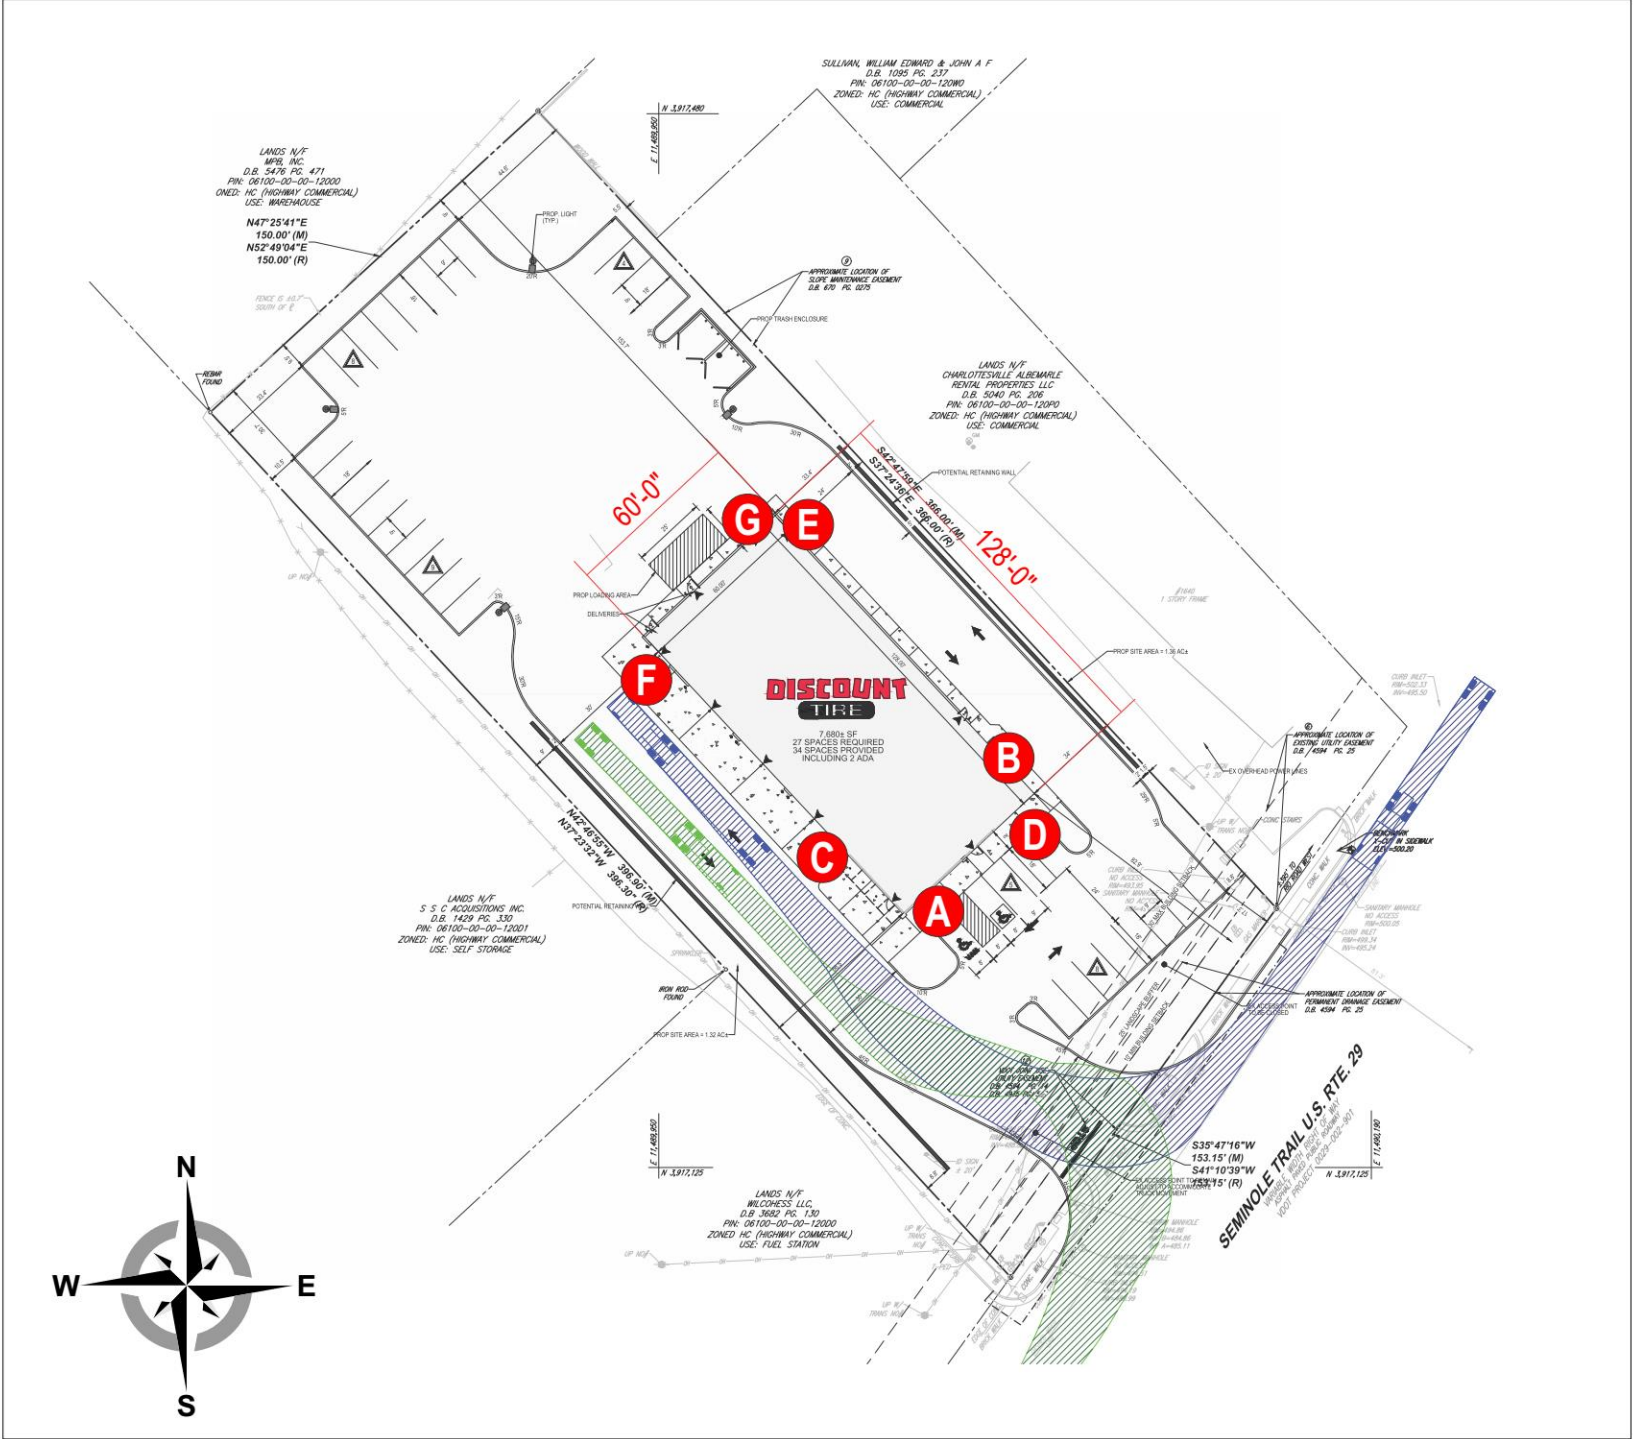


SITE PLAN
Scale: 1/64" = 1'-0"

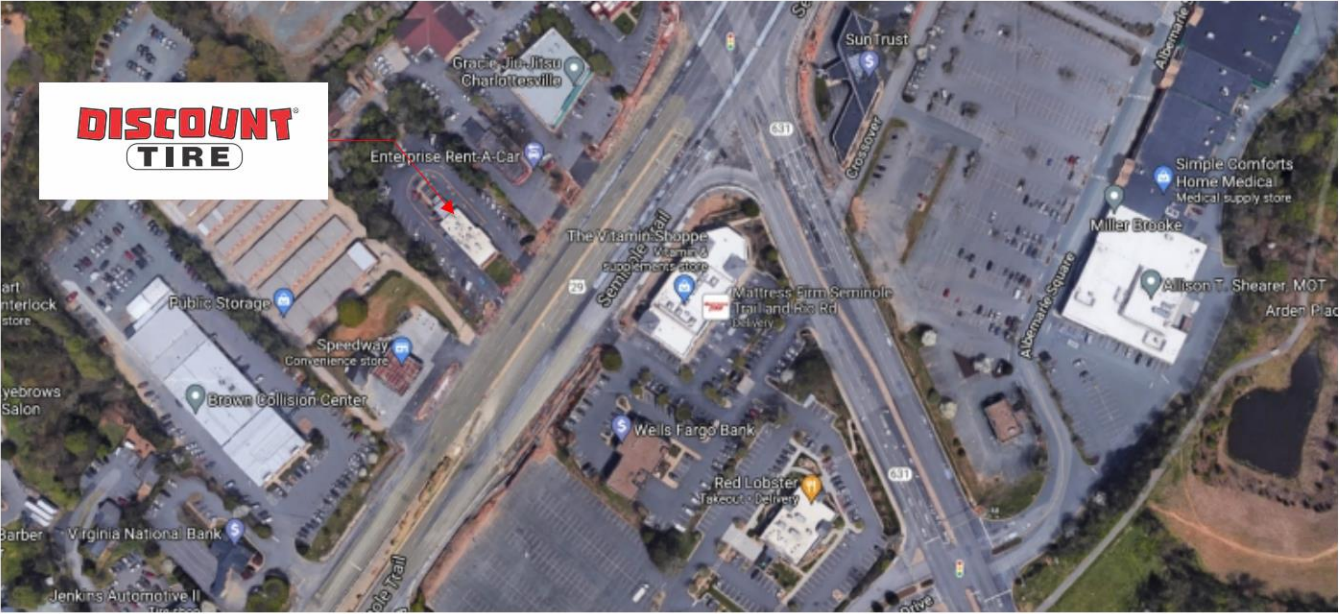


AERIAL VIEW
Scale: Not to Scale

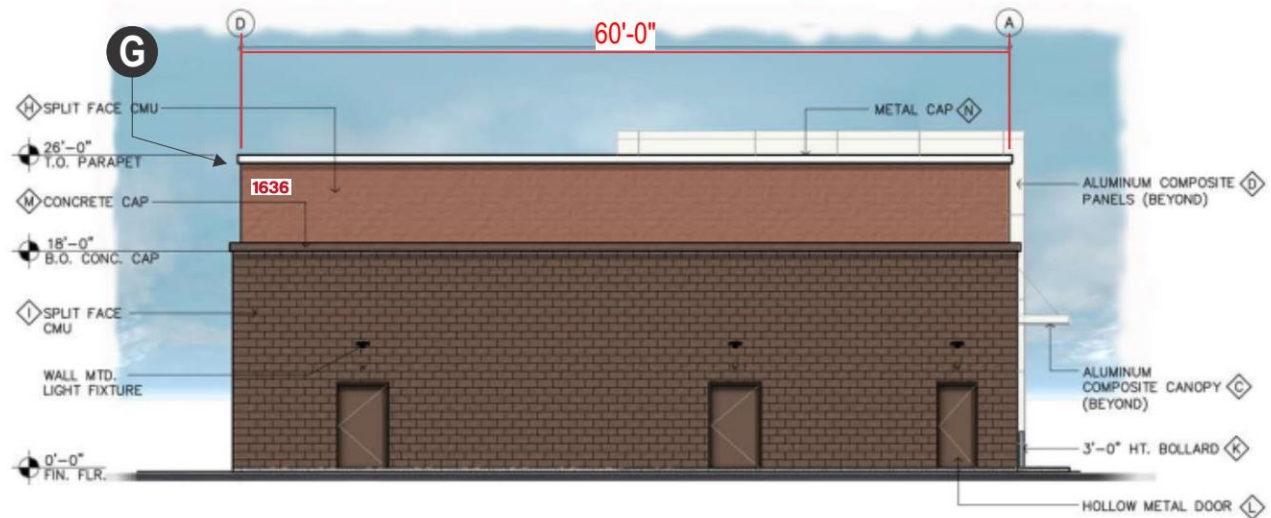


WEST ELEVATION
Scale: 1/16" = 1'-0"

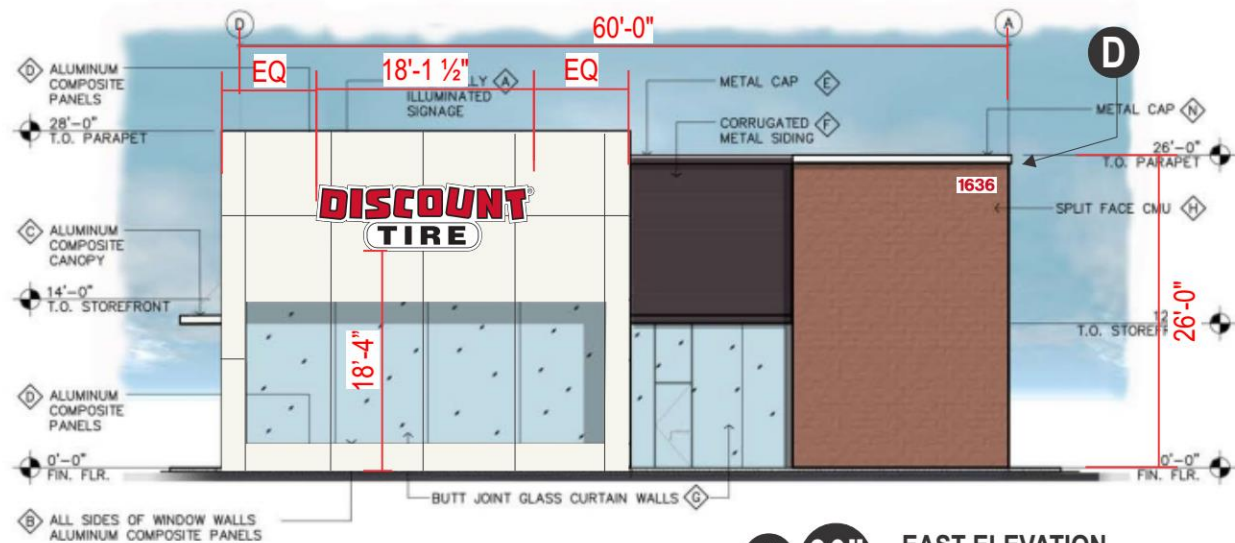


A 30" EAST ELEVATION
Scale: 1/16" = 1'-0"

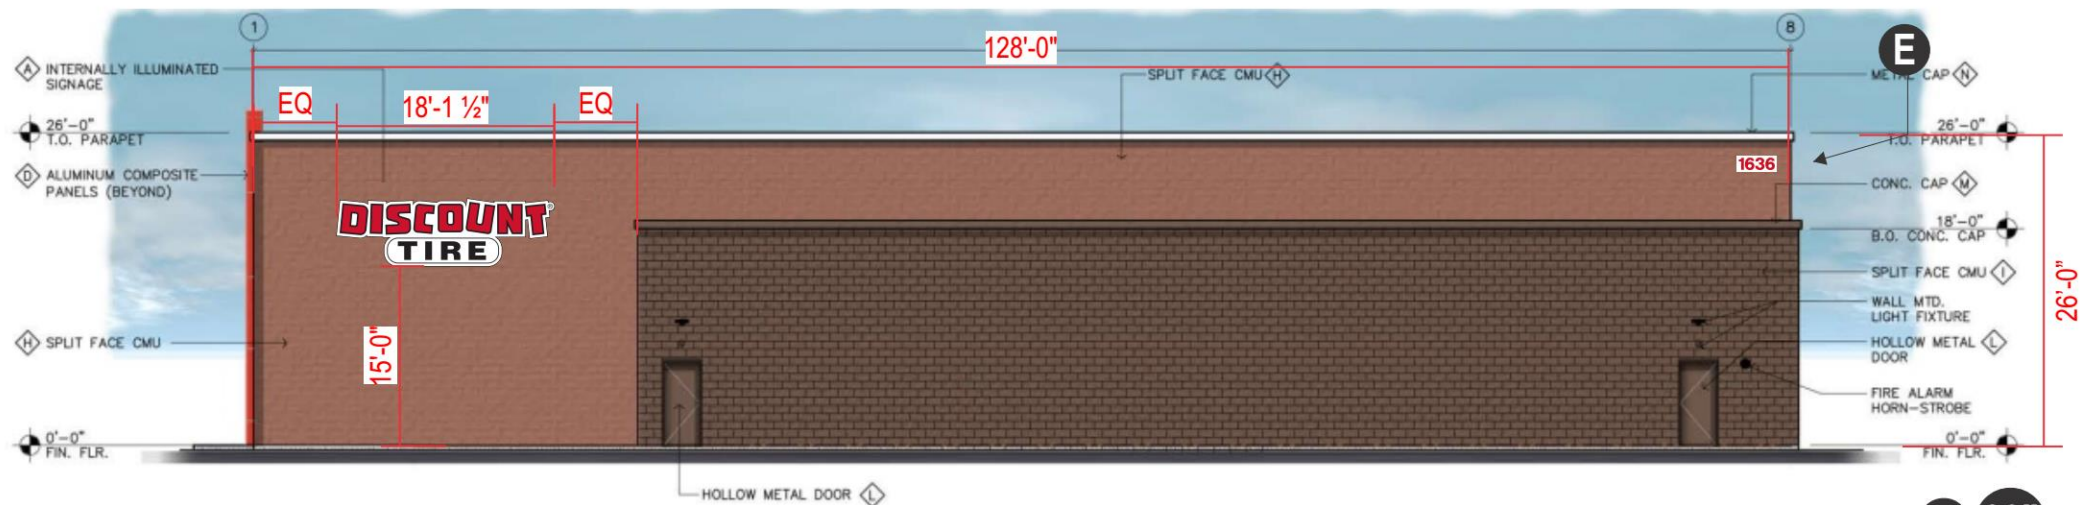

B 30" NORTH ELEVATION
Scale: 1/16" = 1'-0"

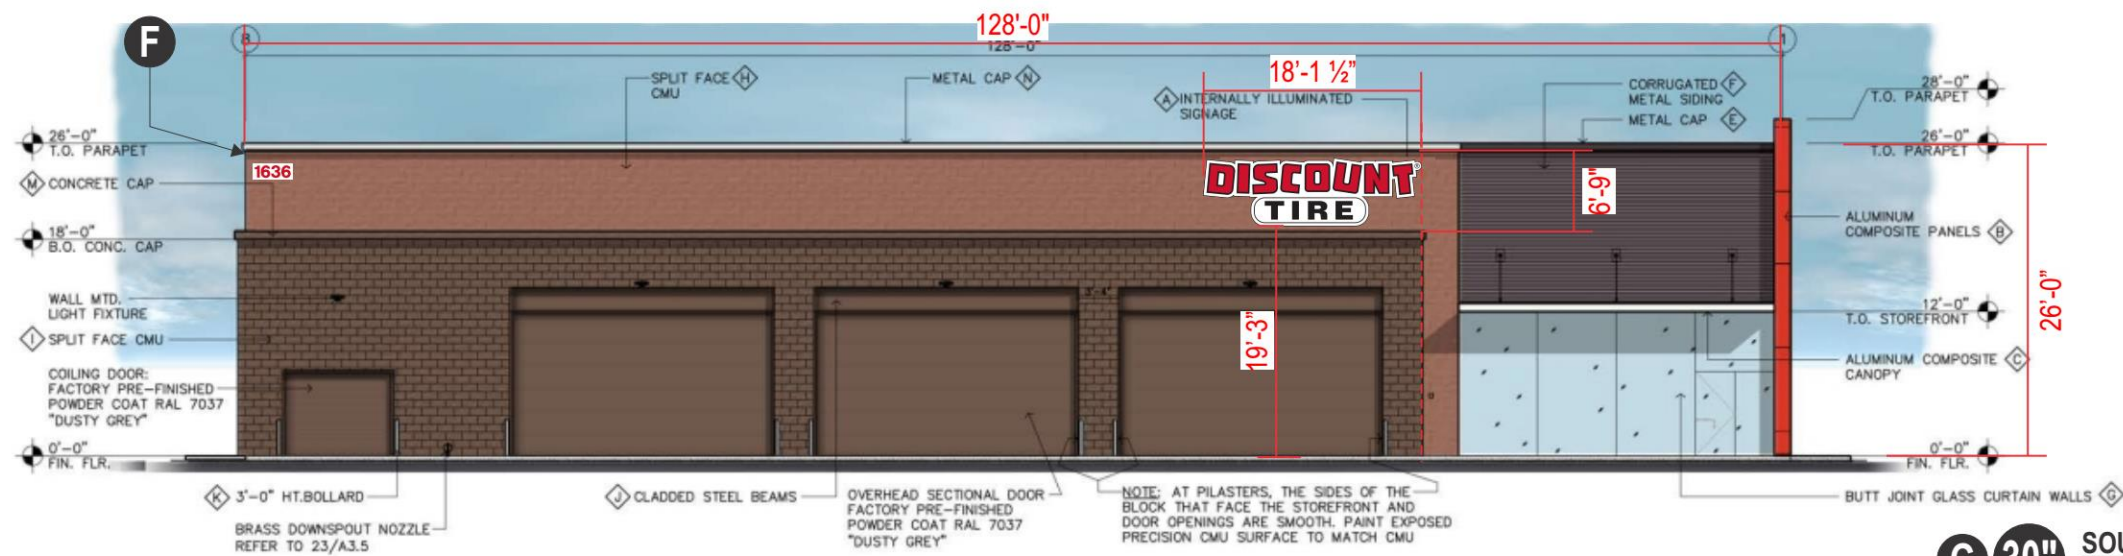

C 30" SOUTH ELEVATION
Scale: 1/16" = 1'-0"

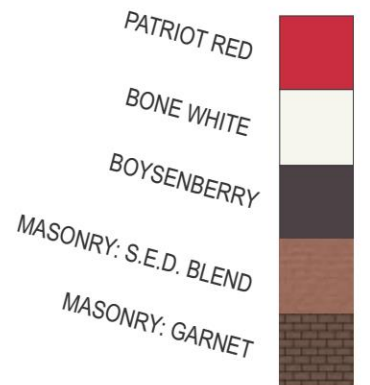

FINISH LEGEND

COLOR / PAINT NOTES:

- A 3-DIMENSIONAL ILLUMINATED SIGN
- B ALUMINUM COMPOSITE PANELS: ALUCOBOND "PATRIOT RED"
- C ALUMINUM CLADDED CANOPY: ALUCOBOND "MATTE/BRUSHED STAINLESS STEEL"
- D ALUMINUM COMPOSITE PANELS: ALUCOBOND "BONE WHITE"
- E 8" METAL CAP BY ATAS INTERNATIONAL INC. COATED "BOYSENBERRY"
- F CORRUGATED METAL PANEL BY ATAS INTERNATIONAL INC. COATED "BOYSENBERRY"
- G STOREFRONT * CLEAR CURTAIN WALL BY C.R. LAURENCE "3250 SERIES"
- H INTEGRAL COLOR SPLIT-FACE C.M.U. BY GRAND BLANC ARCHITECTURAL MASONRY "S.E.D. BLEND"
- I INTEGRAL COLOR SPLIT-FACE C.M.U. BY GRAND BLANC ARCHITECTURAL MASONRY "GARNET"
- J CLADDED STEEL BEAMS: COLOR TO MATCH GRAND BLANC ARCHITECTURAL MASONRY "GARNET"
- K STEEL BOLLARDS: COLOR TO MATCH GRAND BLANC ARCHITECTURAL MASONRY "GARNET"
- L HOLLOW METAL DOORS: PAINTED TO MATCH GRAND BLANC ARCHITECTURAL MASONRY "GARNET"
- M CONCRETE CAP: COLOR TO MATCH GRAND BLANC ARCHITECTURAL MASONRY "GARNET"
- N METAL CAP: COLOR TO MATCH GRAND BLANC ARCHITECTURAL MASONRY "WHITE"



10101 Reunion Place
Suite 500
San Antonio, TX 78216
P 210. 886. 0644
waltonsignage.com
© 2017 WALTON ALL RIGHTS RESERVED

Client: **DISCOUNT TIRE VAC 12457**
Address: **1636 SEMINOLE TRAIL**
City/State: **CHARLOTTESVILLE, VA 22901**
Sales: **IP** Designer: **IP**
Date: **05.24.21** PM **TG**

This is an original drawing created by Walton. It is submitted for your personal use, however, it shall at all times remain the property of Walton. It may be used in connection with the project being planned for you by Walton, but not otherwise. You are not authorized to show these drawings to anyone outside your organization, nor is it to be reproduced, used, copied or exhibited in any fashion.

Revision:

H:\Discount Tire_Locations\VA\VA Charlottesville VAC 12457\318719 Bldg Signage\DESIGNS

Signs will be manufactured with 120 or 277 Volts A/C. All Primary electrical service to the sign, and final connection thereof, is the responsibility of the buyer. All work is to be done in accordance with the purchase agreement attached hereto. In case of variance between the specifications of the purchase agreement and this drawing, the drawing shall prevail.

This sign is intended to be installed in accordance with the requirements of Article 600 of the National Electrical Code and/or other applicable local codes. This includes proper grounding and bonding of the sign.


PAGE SIZE: 11" x 17"

Approvals:

Sales:	Date:
P.M.:	Date:
Design:	Date:
Client:	Date:

CID318719-BDG

Sheet: 3 of 6

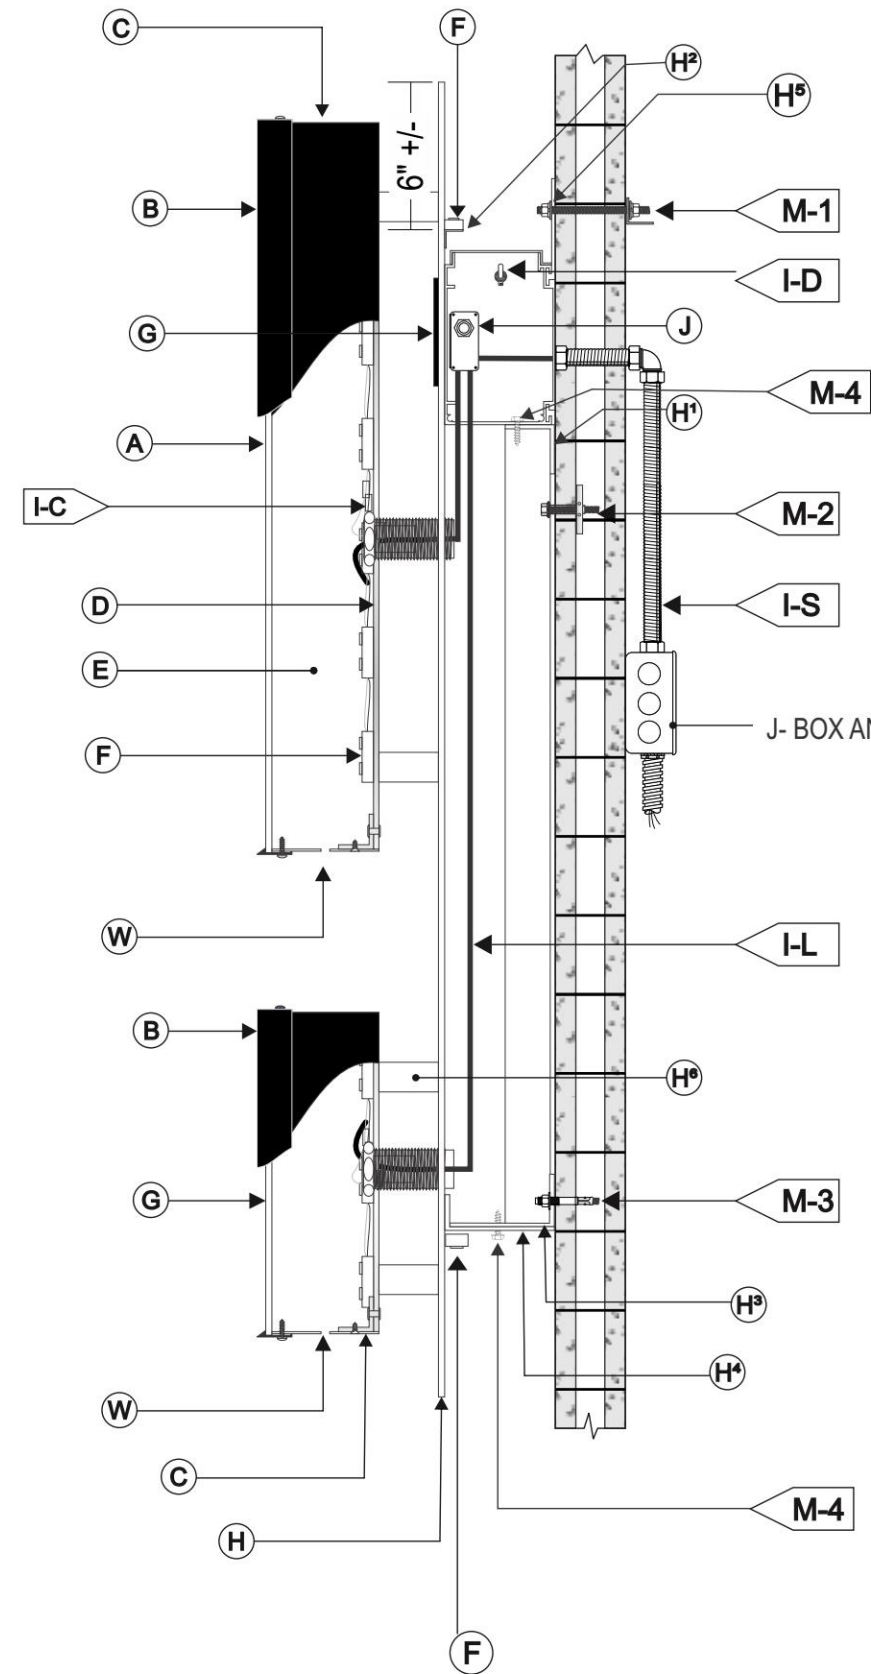

J- BOX AND PRIMARY POWER, BY GC.

WALL FASTENER SCHEDULE (ALL FASTENERS TO BE NON-COROSIVE)
(USE APPROPRIATE METHOD FOLLOWING WALL INSPECTION)

	3/8" Ø THREADED ROD WITH BLOCKING BEHIND WALL	FOR ANY WALL TYPE ONLY TO BE USED WITH PENETRATIONS BELOW ROOF LINE.
	3/8" Ø HEAVY DUTY SNAP TOGGLE	FOR USE WITH HOLLOW CMU WALLS
	3/8" Ø SLEEVE ANCHOR	FOR USE WITH CONCRETE FILLED CMU OR SOLID CONCRETE WALLS 1-1/2" MIN. EMBEDMENT
	3/8" Ø LARGE DIAMETER TAPCON FASTENER 3" MINIMUM EMBEDMENT	FOR USE WITH CONCRETE FILLED CMU OR SOLID CONCRETE WALLS 3" MIN. EMBEDMENT

FACE LIT / HALO ILLUMINATED CHANNEL LETTERS W / BACKER PANEL

SCALE: N.T.S.

A FACE

MATERIAL:	.177 2447 WHITE ACRYLIC
VINYL:	3M 3630-33 RED
	3M 3630-22 BLACK

B TRIMCAPS

SIZE/FINISH	1" BLACK JEWELITE
-------------	-------------------

C RETURNS

DEPTH:	5"
MATERIAL:	ALUM. .040
COLOR:	PRE-PAINT BLACK

D BACKS:

MATERIAL:	.188 WHITE POLYCARBONATE
-----------	--------------------------

E INSIDE OF CAN

COLOR:	WHITE
--------	-------

F ILLUMINATION:

LED:	HANLEY WHITE .80w
------	-------------------

G "TIRE" & REG. MARK:

VINYL:	3M 3630-22 BLACK
REG. MARK:	1ST SURFACE 3630-22 BLACK VINYL

H BACKER PANEL

MATERIAL:	.125 ALUMINUM
H1	2" x 2" x .125 ALUMINUM ANGLE
H2	3/4" x 3/4" x .063 ALUMINUM ANGLE
H3	2" x 4 1/2" x .125 ALUMINUM ANGLE
H4	3" x 4" x .125 ALUMINUM ANGLE
H5	RACEWAY MOUNTING CLIP

H6	2" SPACER
----	-----------

COLOR:	WHITE
--------	-------

I WIRING

I-S	1/2" FLEX PER CODE
I-C	1/2" CONNECTOR PER CODE
I-L	12v JACKETED CABLE
I-D	UL LISTED DISCONNECT SWITCH

J POWER SUPPLY

TYPE:	12V POWER SUPPLY
	HOUSE IN 4" X 4" RACEWAY, TOP ACCESS
VOLTAGE:	120V PRIMARY / 12V SECONDARY
	GC BRINGING PRIMARY POWER TO SIGN

M MOUNTING

M-1	3/8" THREADED ROD (SEE FASTENER SCHEDULE)
M-2	3/8" SNAP TOGGLE (SEE FASTENER SCHEDULE)
M-3	3/8" SLEEVE ANCHOR (SEE FASTENER SCHEDULE)
M-4	MOUNTING FASTENER SCREWS

W WEEPHOLES:	1/4" DIA. WITH COVER
--------------	----------------------

NOTES: SEAL ALL PENETRATIONS WATER TIGHT CONDITIONS

NOTES:

- 1.ALL SEAMS PLACED AT TOP FOR MINIMUM VISIBILITY.
- 2.INSTALLATION TO CONFORM WITH SECTION 600 OF NEC.
- 3.LETTERS FABRICATED TO UL STANDARDS.
- 4.LETTERS TO BE CONSTRUCTED TO PREVENT LIGHT LEAKS.
- 5.WEEP HOLES ARE FOR EXTERIOR LOCATIONS ONLY.

ELECTRICAL NOTE: IT IS THE CUSTOMERS RESPONSIBILITY TO PROVIDE 120 VOLT PRIMARY ELECTRICAL SERVICE WITH DEDICATED CIRCUIT(S). INCLUDING GROUND WIRING DIRECTLY FROM PANEL BOX WITHIN SIX (6) FEET OF SIGNAGE. INSTALLATION TO MEET N.E.C., UL & LOCAL CODES

MOUNTING NOTE: INSTALLER IS REQUIRED TO VERIFY ACTUAL FIELD CONDITIONS & PROVIDE NECESSARY MOUNTING HARDWARE & METHOD OF ATTACHMENT TO ENSURE SAFE INSTALLATION. INSTALLATION TO MEET N.E.C., UL & LOCAL CODES.

Revision:

Signs will be manufactured with 120 or 277 Volts A/C. All Primary electrical service to the sign, and final connection thereof, is the responsibility of the buyer. All work is to be done in accordance with the purchase agreement attached hereto. In case of variance between the specifications of the purchase agreement and this drawing, the drawing shall prevail.

This sign is intended to be installed in accordance with the requirements of Article 600 of the National Electrical Code and/or other applicable local codes. This includes proper grounding and bonding of the sign.

PAGE SIZE: 11" x 17"

Approvals:

Sales:	Date:
P.M.:	Date:
Design:	Date:
Client:	Date:

CID318719-BDG

